



- GENERAL NOTES**
1. ALL WORK SHALL BE PERFORMED AND COMPLETED IN ACCORDANCE WITH THE "STANDARD SPECIFICATIONS FOR PUBLIC WORKS CONSTRUCTION", 1988 EDITION, AND ALL SUPPLEMENTS THERETO, HERIN REFERRED TO AS THE STANDARD SPECIFICATIONS, PROJECT PLANS AND SPECIAL PROVISIONS.
 2. THE CONTRACTOR SHALL TAKE ALL NECESSARY AND PROPER PRECAUTIONS TO PROTECT ADJACENT PROPERTIES FROM ANY DAMAGE, INCLUDING ANY RUNOFF FROM STORM OR CONSTRUCTION WATER, THAT MAY OCCUR DURING THE PERFORMANCE OF THE WORK.
 3. EXISTING UTILITIES SHALL BE MAINTAINED IN PLACE BY THE CONTRACTOR, UNLESS OTHERWISE NOTED.
 4. THE CONTRACTOR SHALL NOTIFY THE PUBLIC WORKS INSPECTOR PRIOR TO ANY REQUIRED INSPECTION IN ACCORDANCE WITH THE CONTRACT DOCUMENTS.
 5. CONTRACTOR SHALL NOTIFY UNDERGROUND SERVICE ALERT TWO WORKING DAYS PRIOR TO THE START OF GRADING WORK. TELEPHONE 800-422-4133.
 6. REFER TO SHEET 2 FOR LAYOUT INFORMATION FOR PARKING LOT, OTHER PAVED AREAS, STRUCTURES & MISC. HARDSCAPE. FOR ITEMS NOT DIMENSIONED, SCALING OF CONTRACT PLANS IS PERMITTED.
 7. ALL CONCRETE SHALL BE 3000 PSI 28 DAY STRENGTH, MAX 3" SLUMP.
 8. A.C. PAVEMENT TO BE CLASS B, AR 4000.

- CONSTRUCTION NOTES:**
- (1A) FURNISH & INSTALL CATCH BASIN #7 PER L.A. CO. FLOOD CONTROL DISTRICT STD. DRAWING 2-D170.
 - (1B) CONSTRUCT 18' WIDE ACCESS DRIVEWAY OF 4" A.C. OVER 6" A.B.
 - (1) CONSTRUCT LOCAL DEPRESSION CASE "C" (6'-24") PER L.A. CO. FLOOD CONTROL DISTRICT STD. DRAWING 2-DB8.
 - (2) CONSTRUCT CURB & GUTTER TYPE "A-4" PER L.A. CO. ROAD DEPT. STD. DRAWING 28-01.
 - (3) FURNISH & INSTALL PICNIC BENCHES AS SHOWN IN DETAIL B/2. 7 TOTAL, 2 SHALL BE HANDICAPPED AS INDICATED ON PLAN.
 - (4) CONSTRUCT DIRT BERM AS SHOWN IN DETAIL B/1.
 - (5) RECONSTRUCT CONCRETE SWALE AS SHOWN ON PLAN, & PER DETAIL H/2.
 - (6) CONSTRUCT 6" CONCRETE CURB PER DETAIL C/2.
 - (7) CONSTRUCT 4 1/2" D.G. TRAIL PER DETAIL D/2.
 - (8) FURNISH & INSTALL PIPE BOLLARD AS SHOWN IN DETAIL E/2.
 - (9) CONSTRUCT TOT LOT PER DETAIL F/2.
 - (10) CONSTRUCT PARKING LOT PER DETAIL G/2 AND G/2.
 - (11) FURNISH & INSTALL 4" VCP SEWER LINE.
 - (12) FURNISH & INSTALL SEWER MANHOLE "A" PER L.A. CO. SANITATION DISTRICT STD. DRAWING NO. S-a-201.
 - (13) FURNISH & INSTALL SEWER CLEAN OUT PER L.A. CO. SANITATION DISTRICT STD. DRAWING NO.
 - (14) FURNISH & INSTALL MODIFIED CATCH BASIN #1 PER L.A. CO. FLOOD CONTROL DISTRICT STD. DRAWING 2-D160, ALSO SEE DETAIL A/1.
 - (15) FURNISH & INSTALL 18" STORM DRAIN PIPE D=2000.
 - (16) FURNISH & INSTALL 1" WATER LATERAL PER CALAM WATER CO. STD DWG 3.

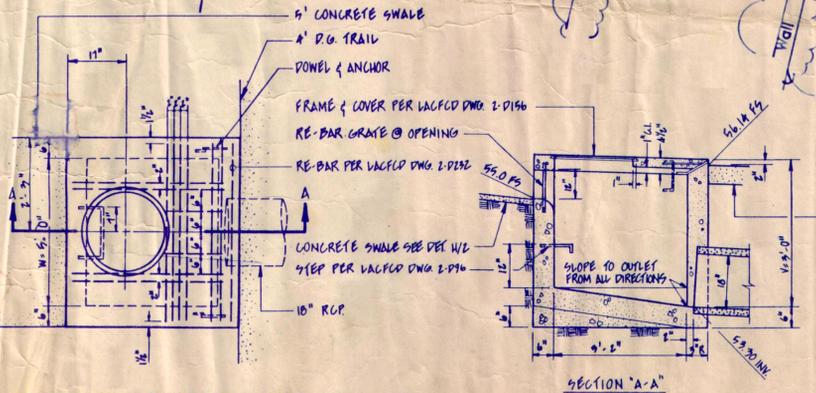

MODIFIED CATCH BASIN DETAIL

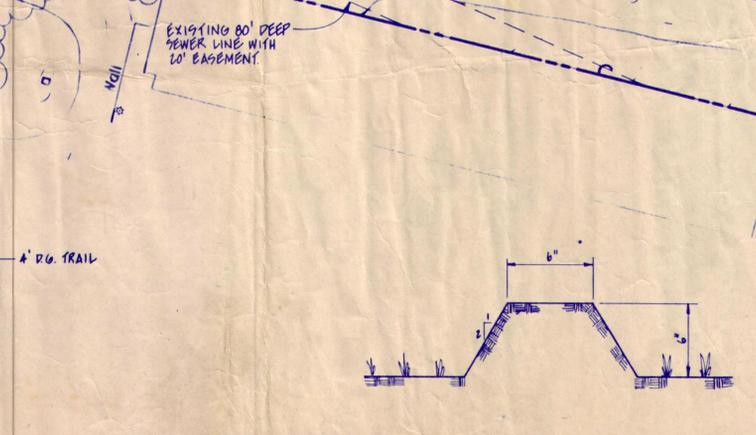

DIRT BERM DETAIL

REVISIONS			
NO.	DESCRIPTION	DATE	BY

RANCHO PALOS VERDES		
EASTVIEW PARK		
GRADING PLAN		
SCALE: 1"=40'	APPROVED BY CITY ENGINEER	DATE
DESIGNED: DC	DWIGHT FRENCH & ASSOCIATES 708 N. DIAMOND BAR BOULEVARD DIAMOND BAR, CALIFORNIA 91765 (714) 860-3586	JOB NUMBER 286-005-89
DRAWN: YC		FILE NUMBER
CHECKED:		SHEET OF
PROJECT ENGINEER: DE		DATE