




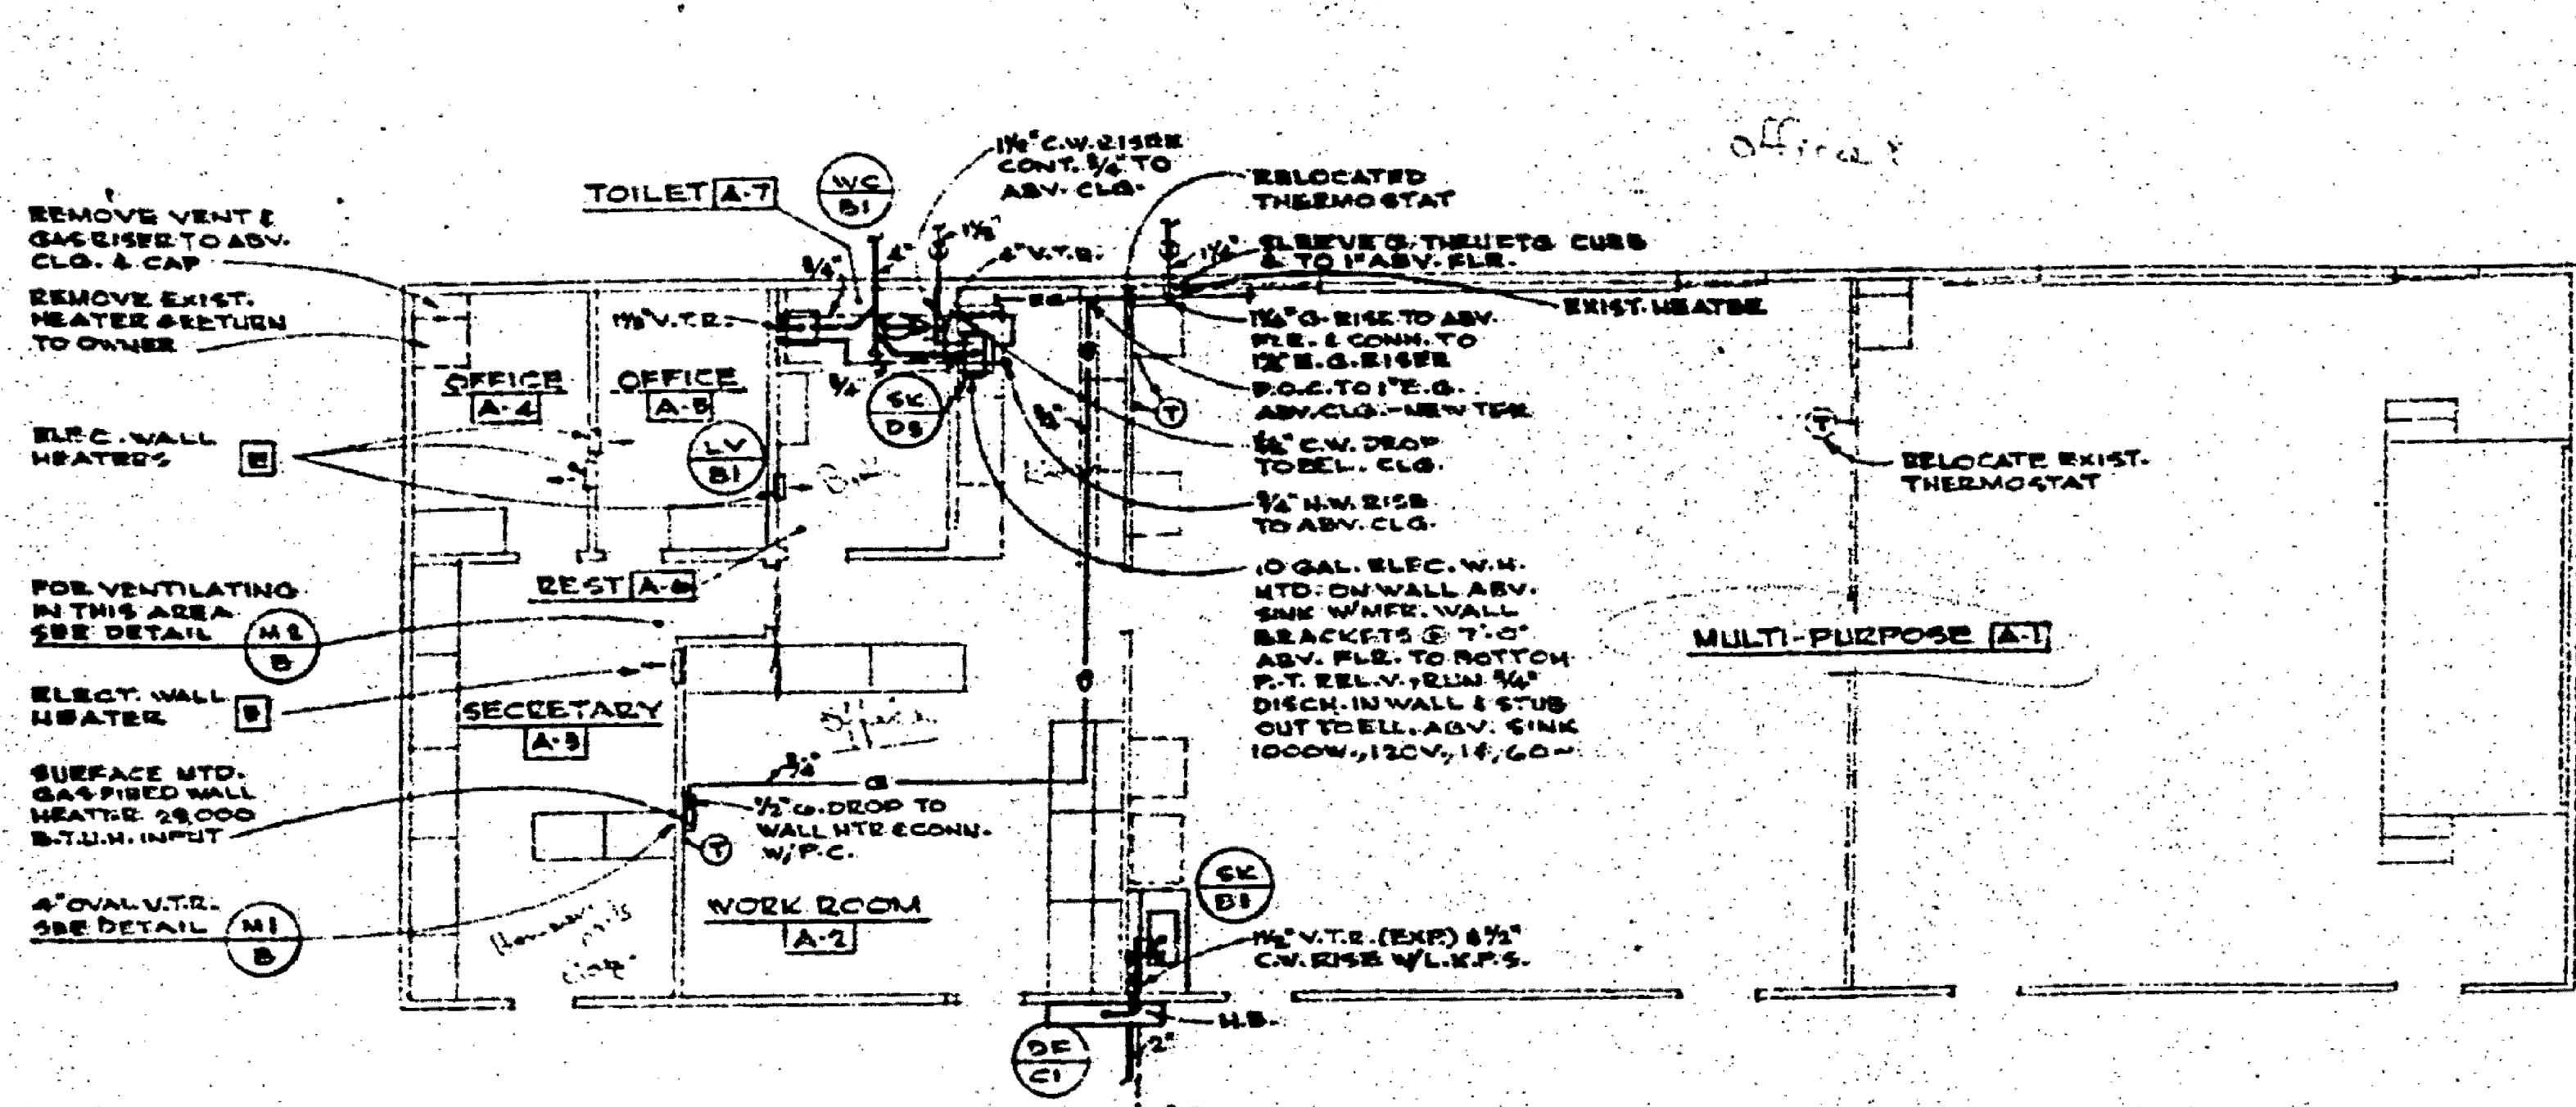


FLOOR PLAN UNIT 'A'
SCALE 1/8"=1'-0"

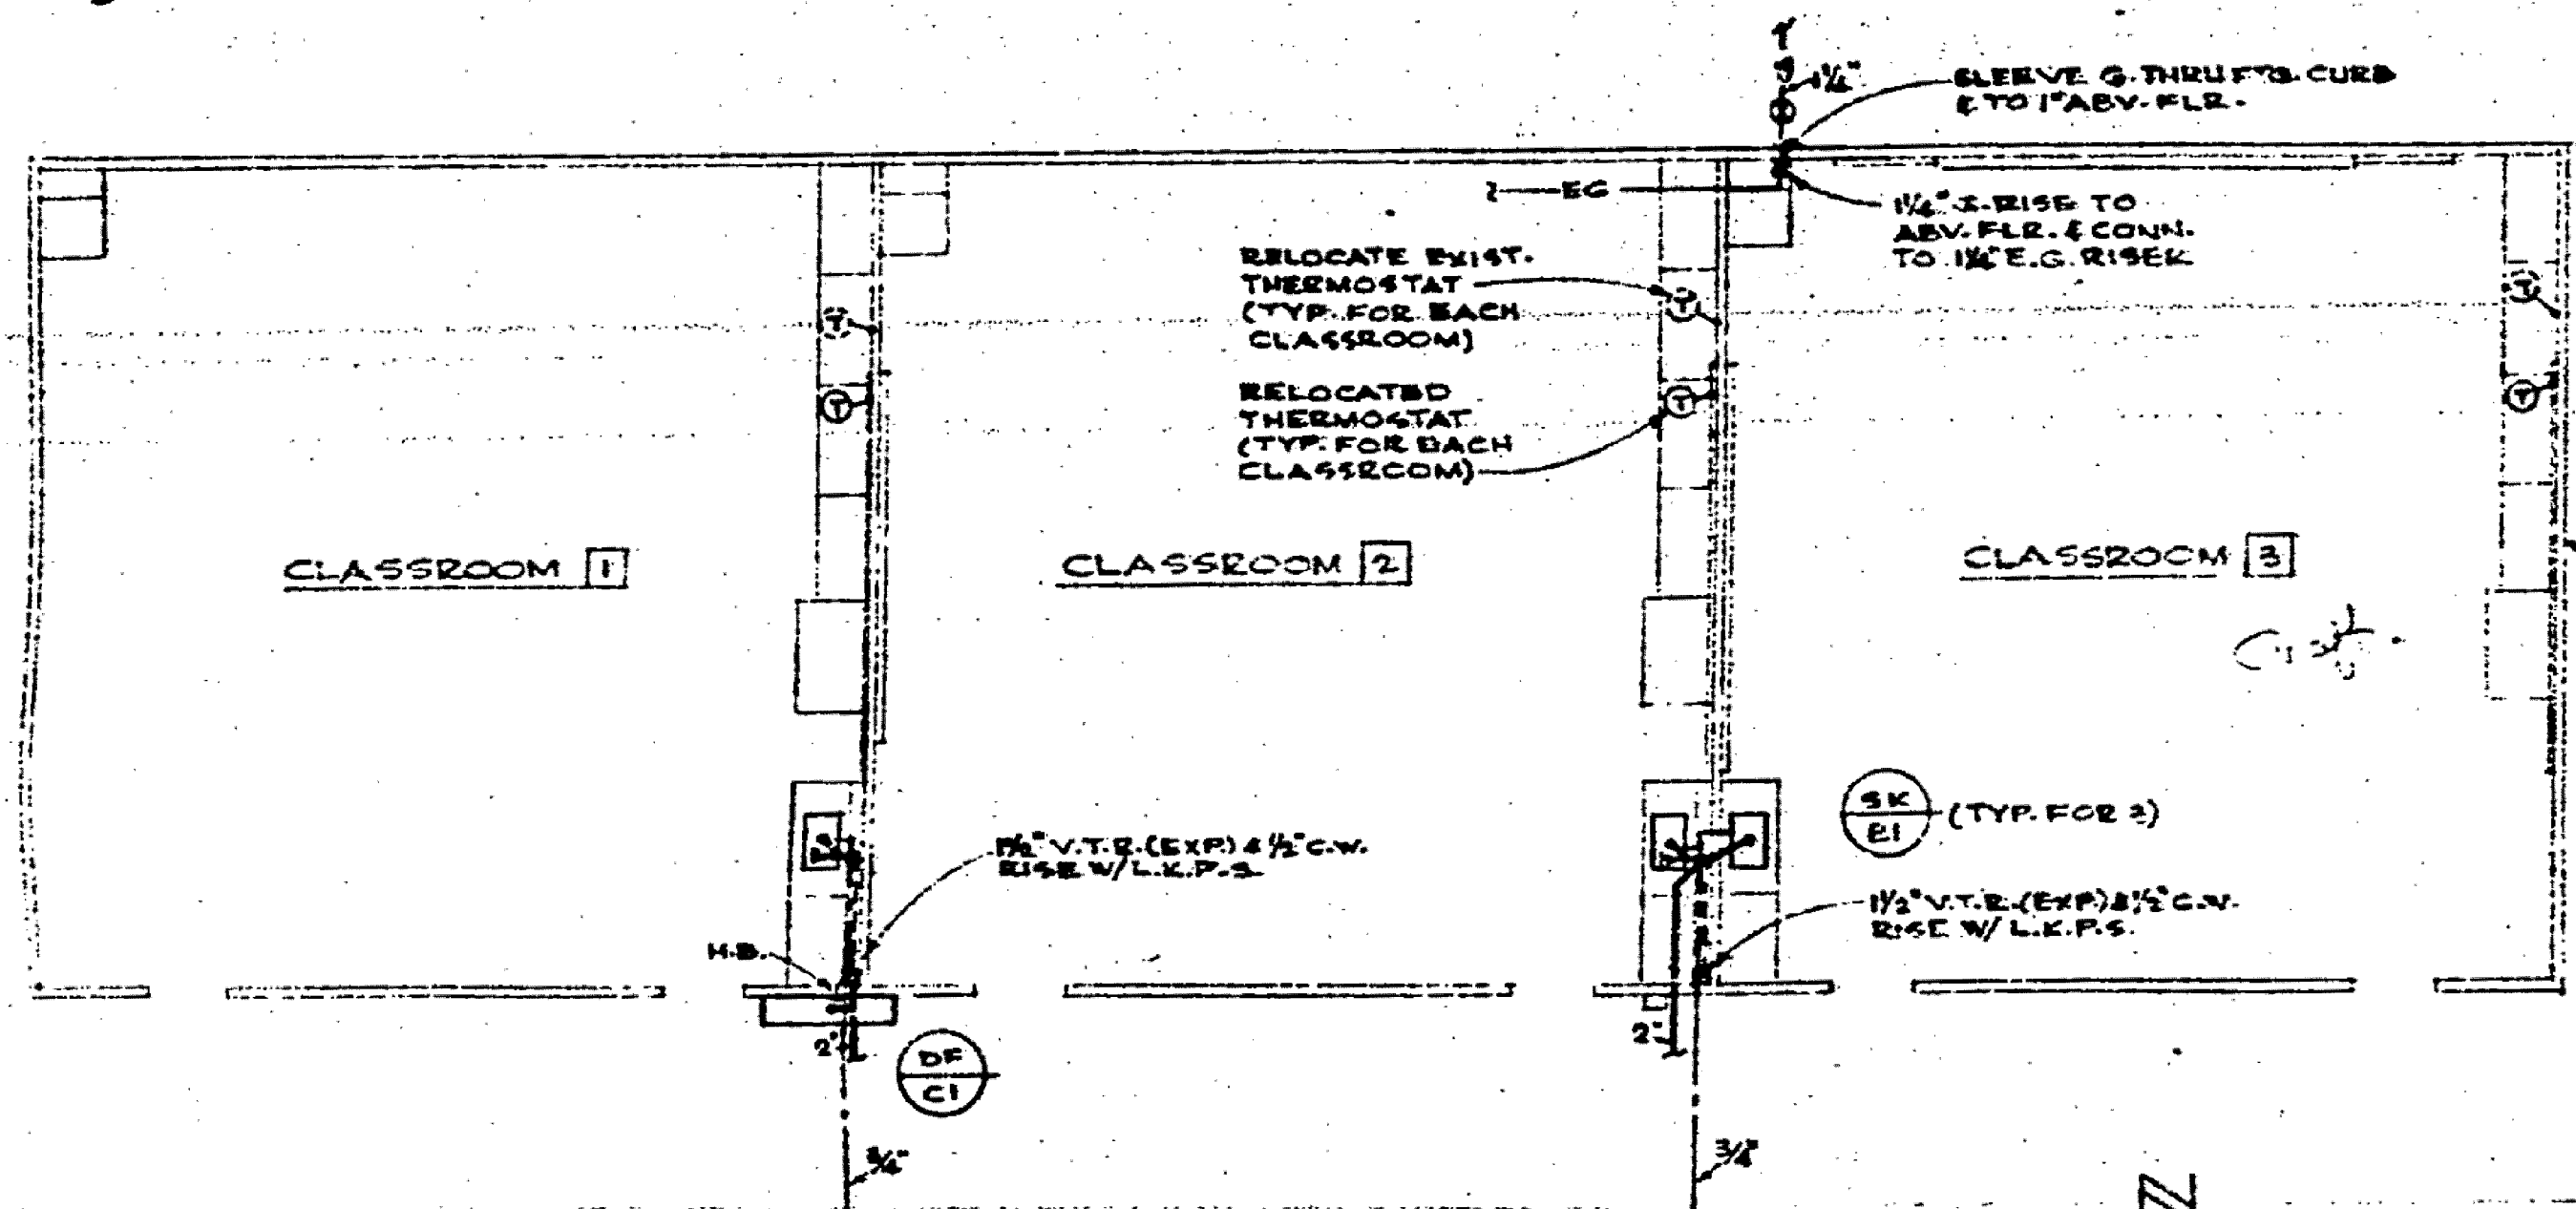

FLOOR PLANS UNITS 'B', 'C', & 'D'
SCALE 1/8"=1'-0"

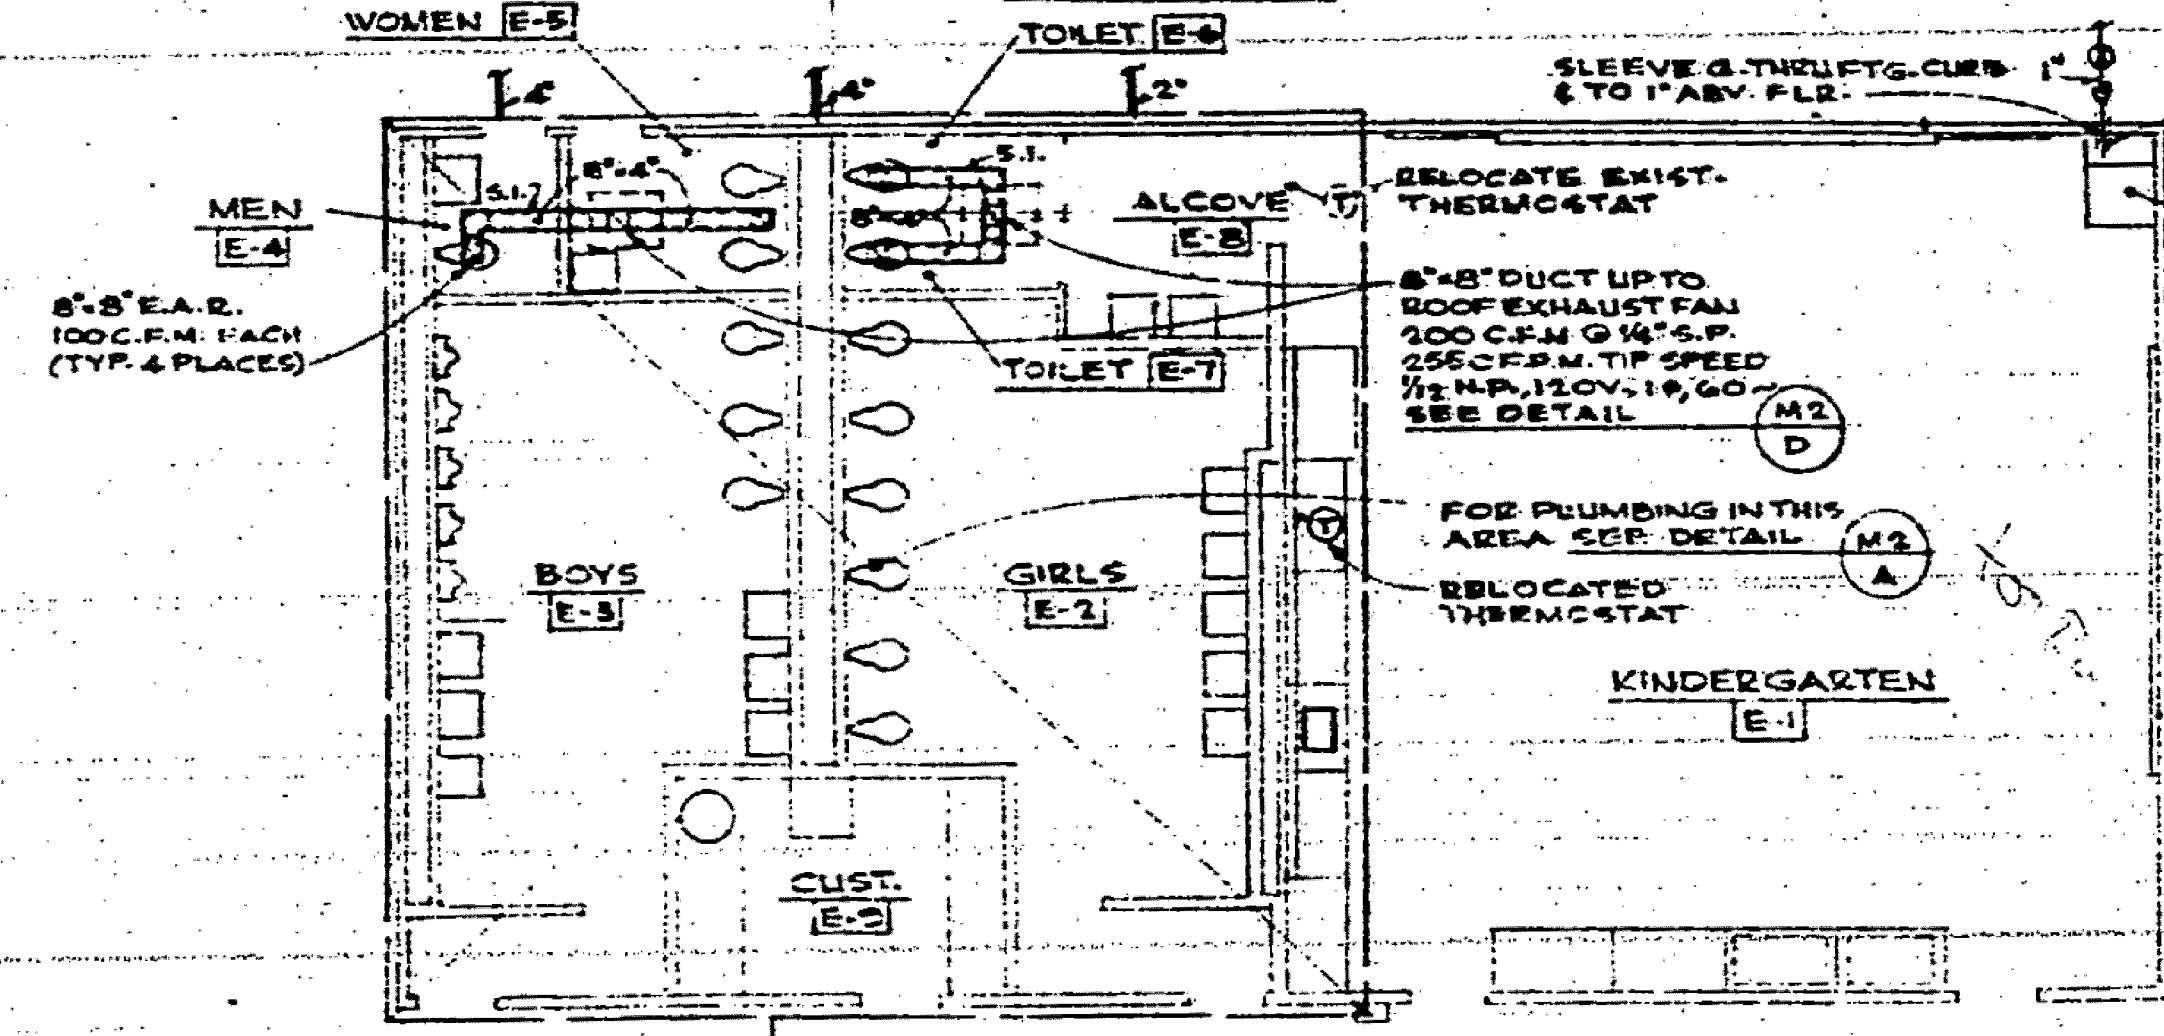


FLOOR PLAN UNIT 'E'
SCALE 1/8"=1'-0"

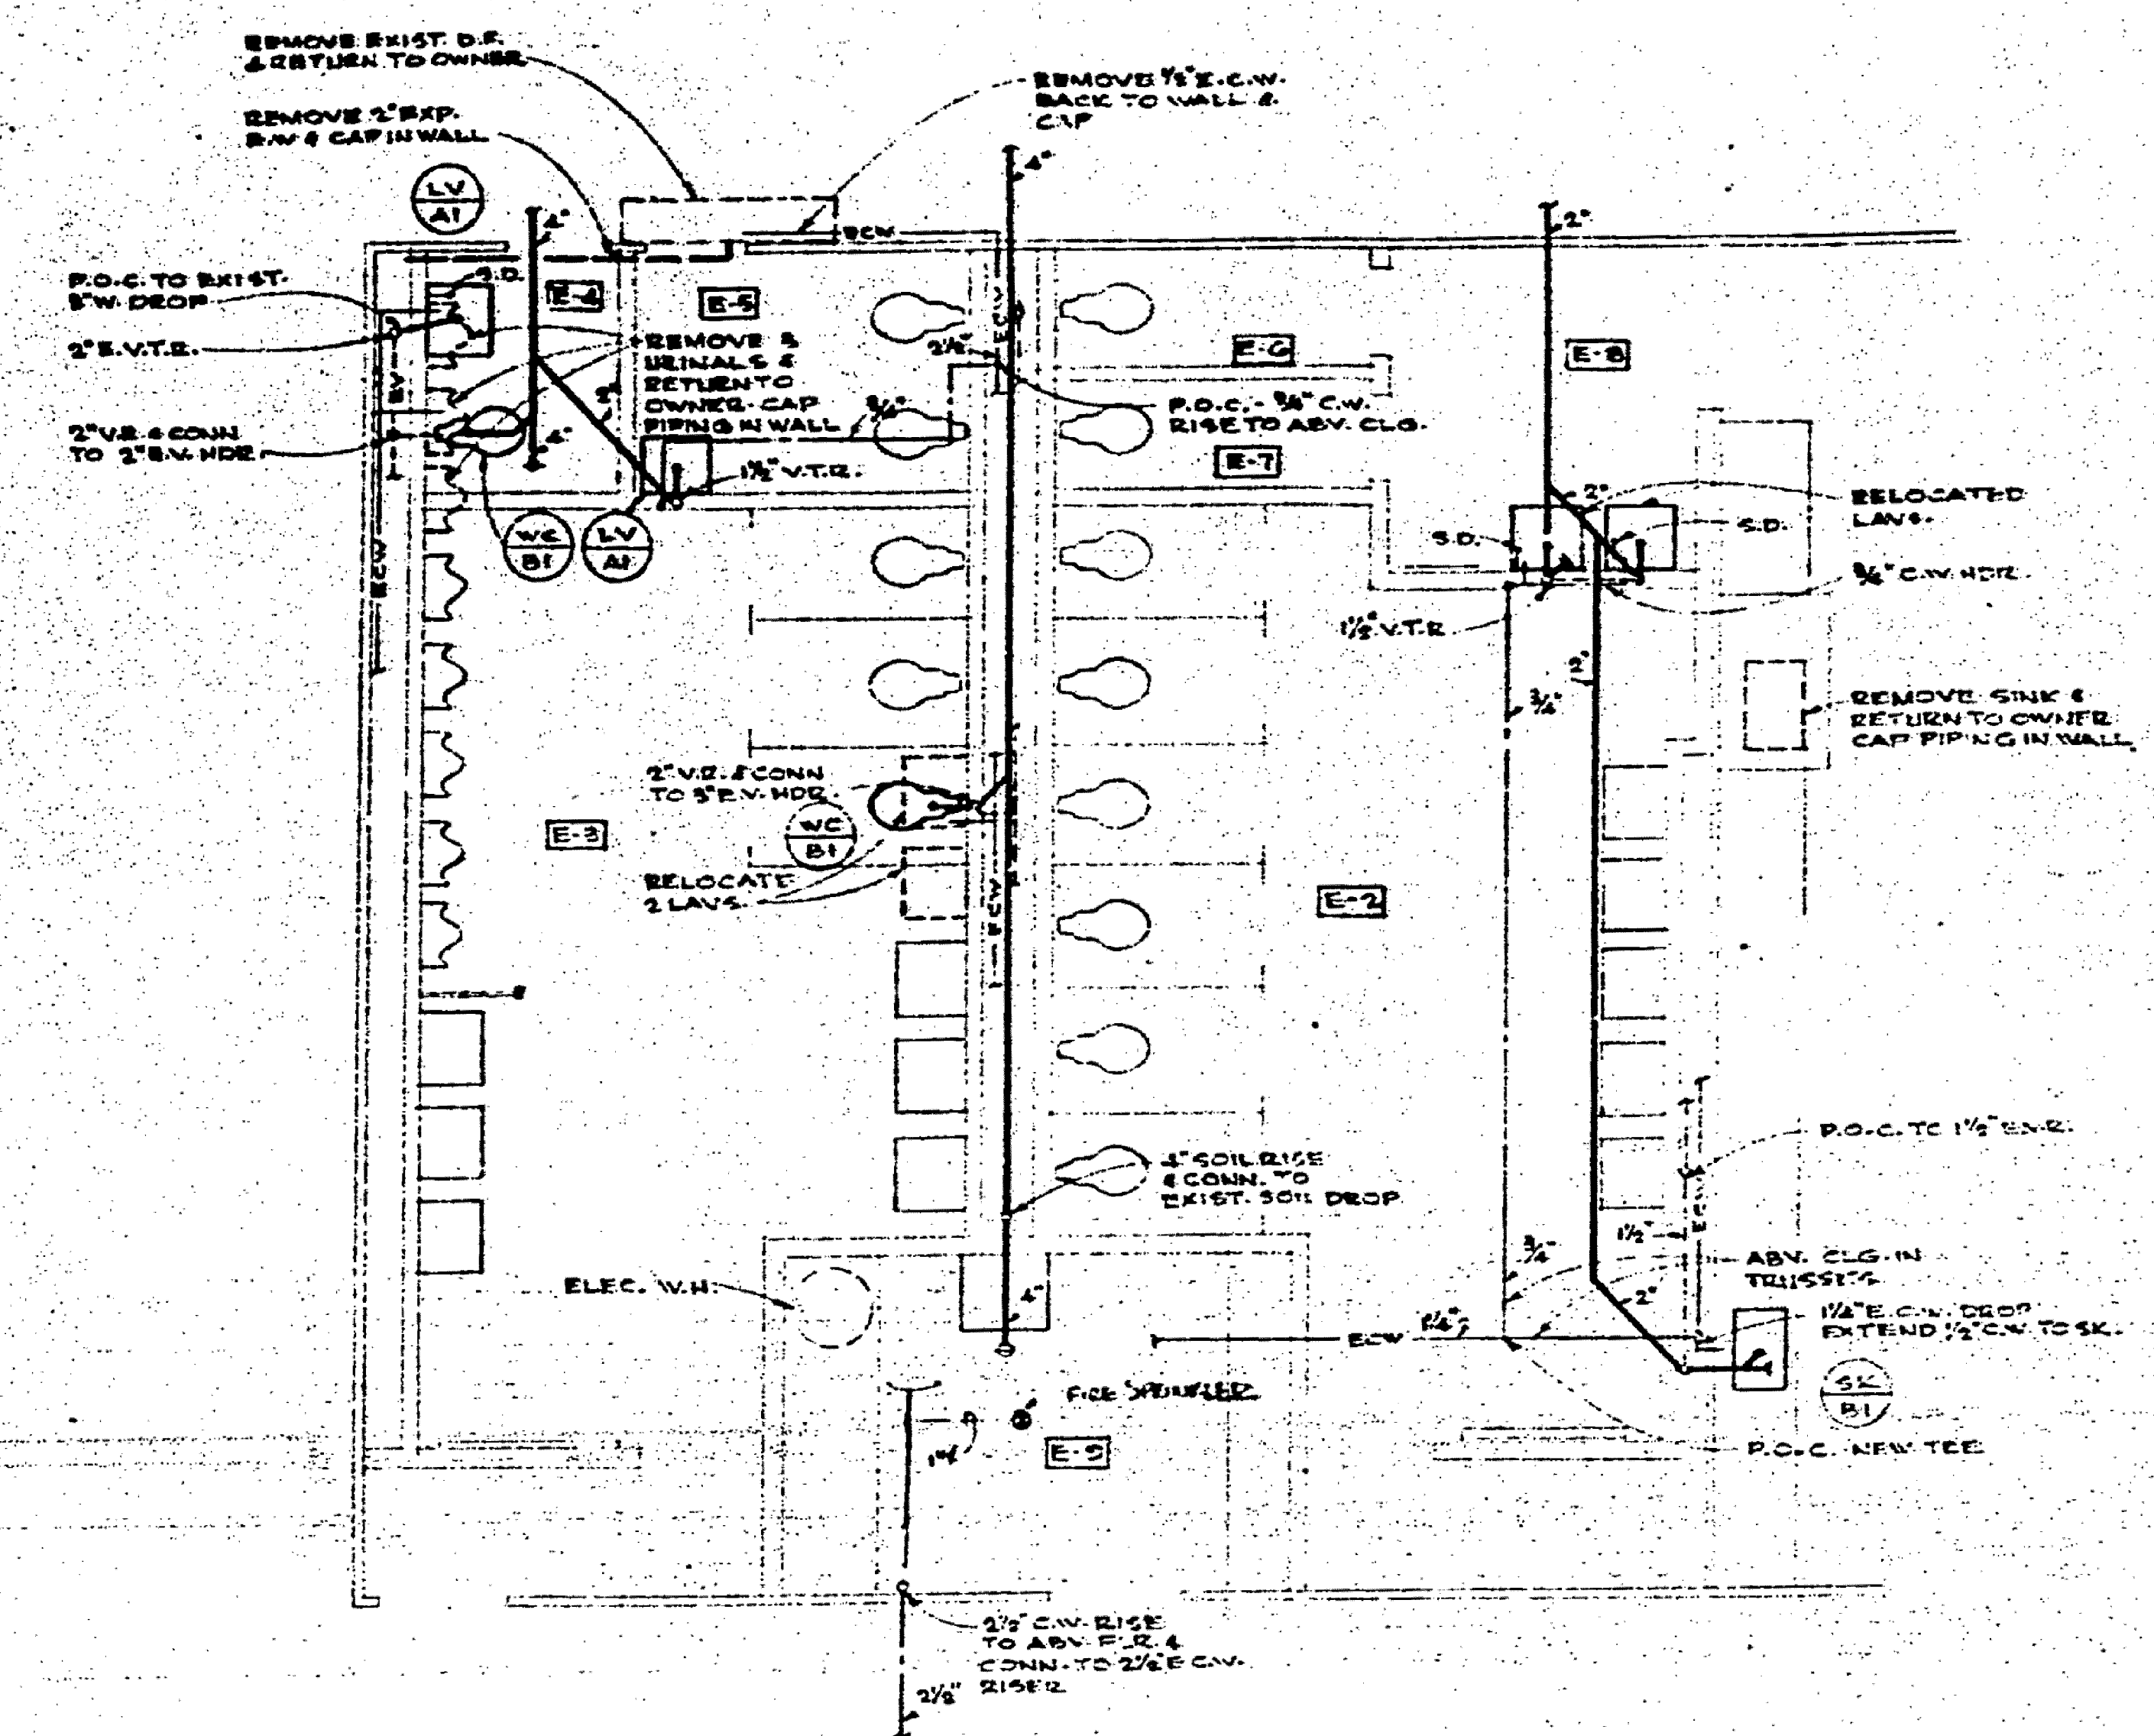


DETAIL M-1
SCALE 1/4"=1'-0"


VENTILATING ABBREVIATIONS
 E.A.R. EXHAUST AIR REGISTER
 E.A.R. EXHAUST AIR REGISTER
 S.I. SOUND INSULATION
 [A] FURNISHED & INSTALLED UNDER THE ARCHITECTURAL DIVISION OF THE SPECIFICATIONS.
 [E] FURNISHED & INSTALLED UNDER THE ELECTRICAL DIVISION OF THE SPECIFICATIONS.

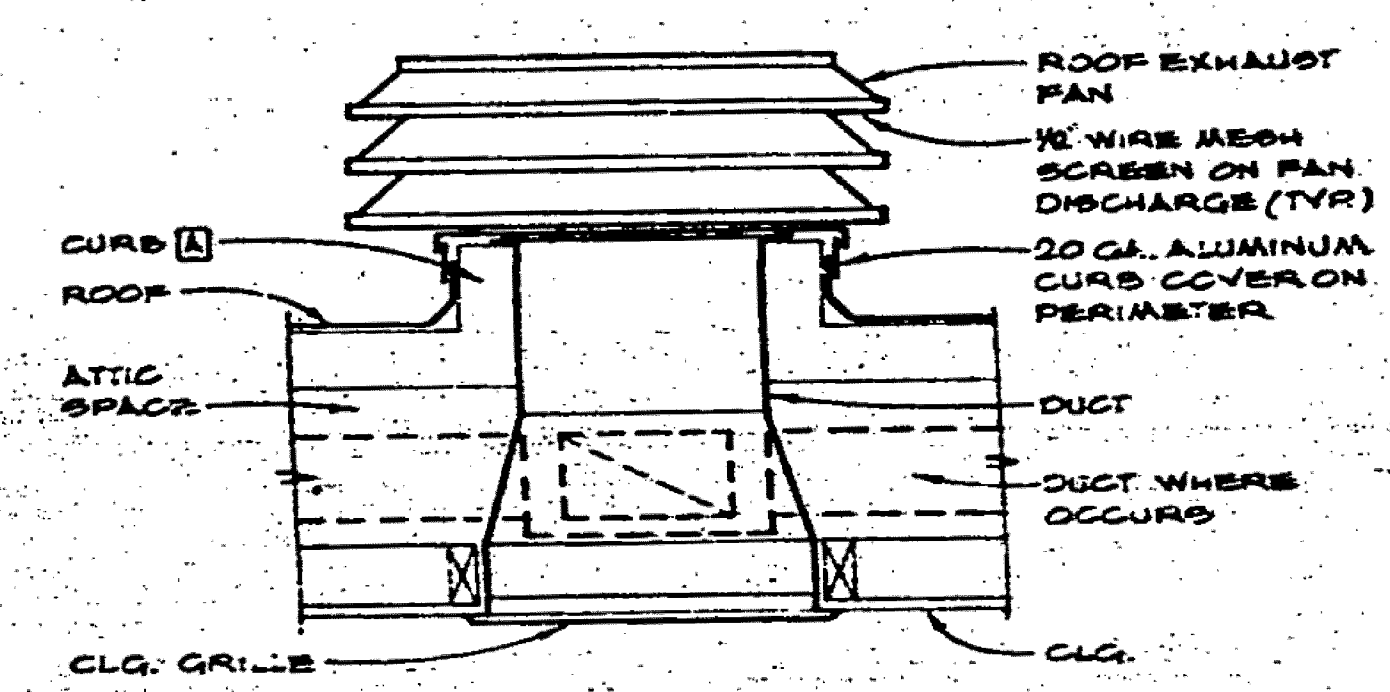

DETAIL M-2

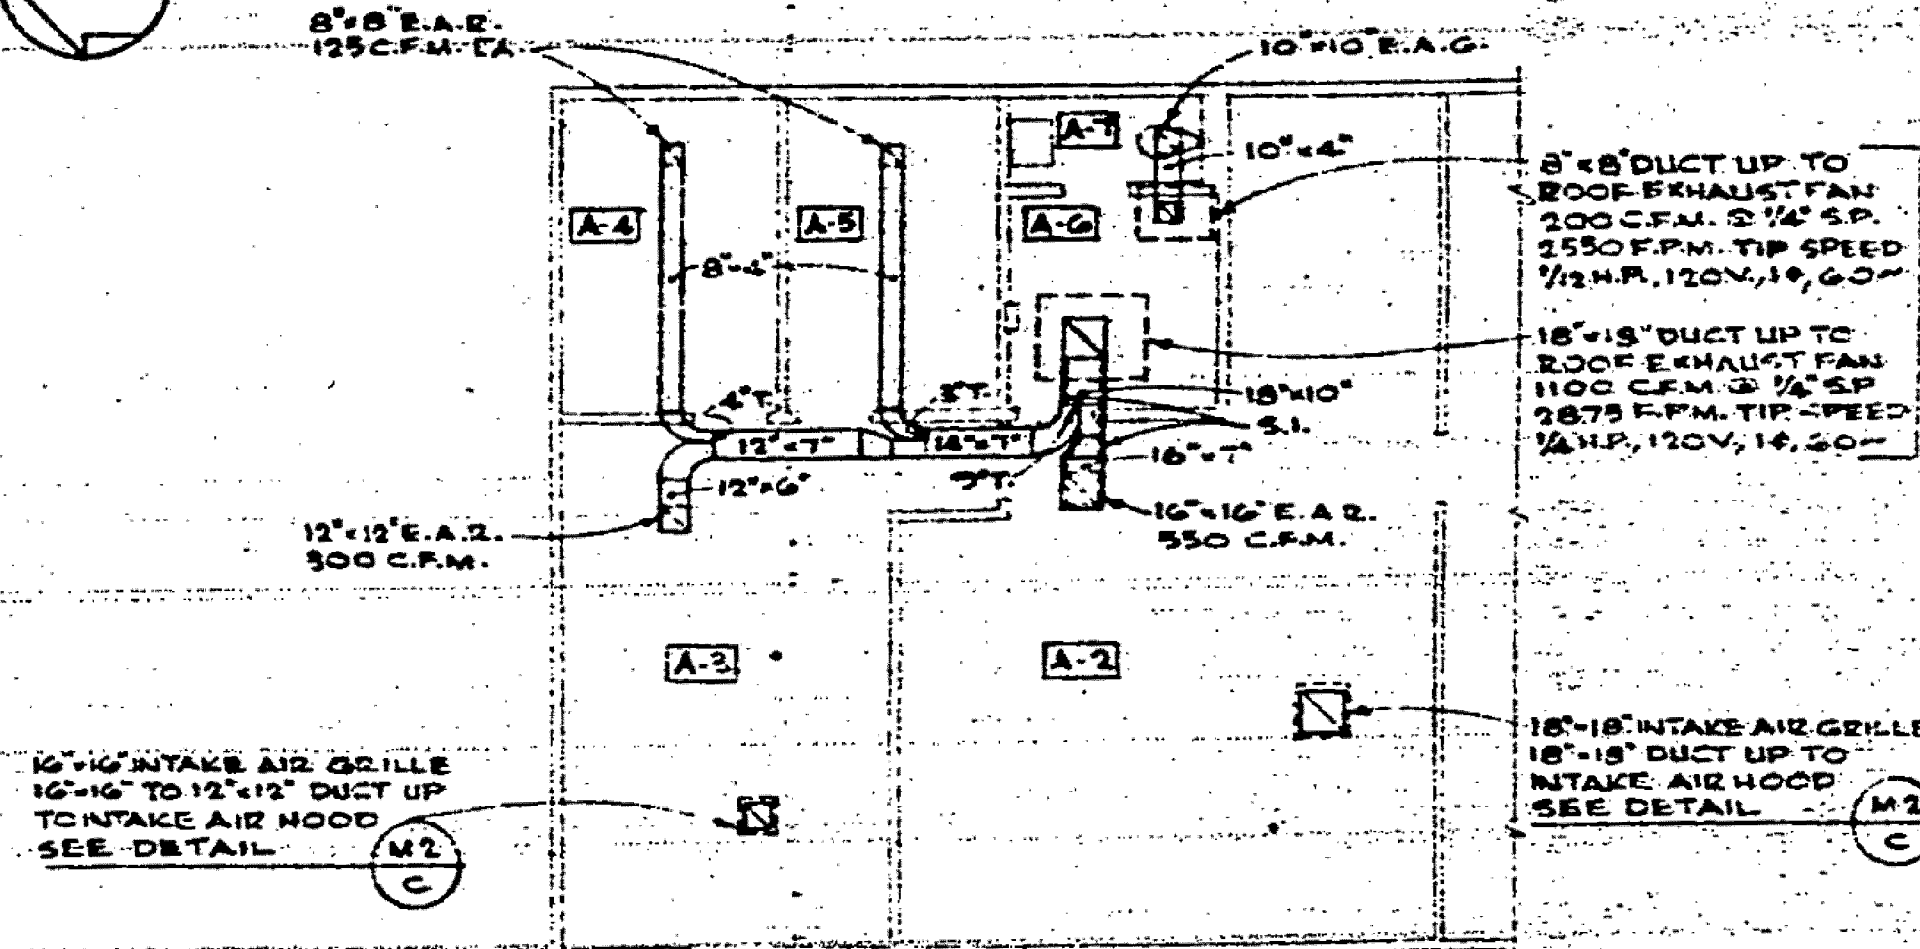

DETAIL M-3
SCALE 1/4"=1'-0"

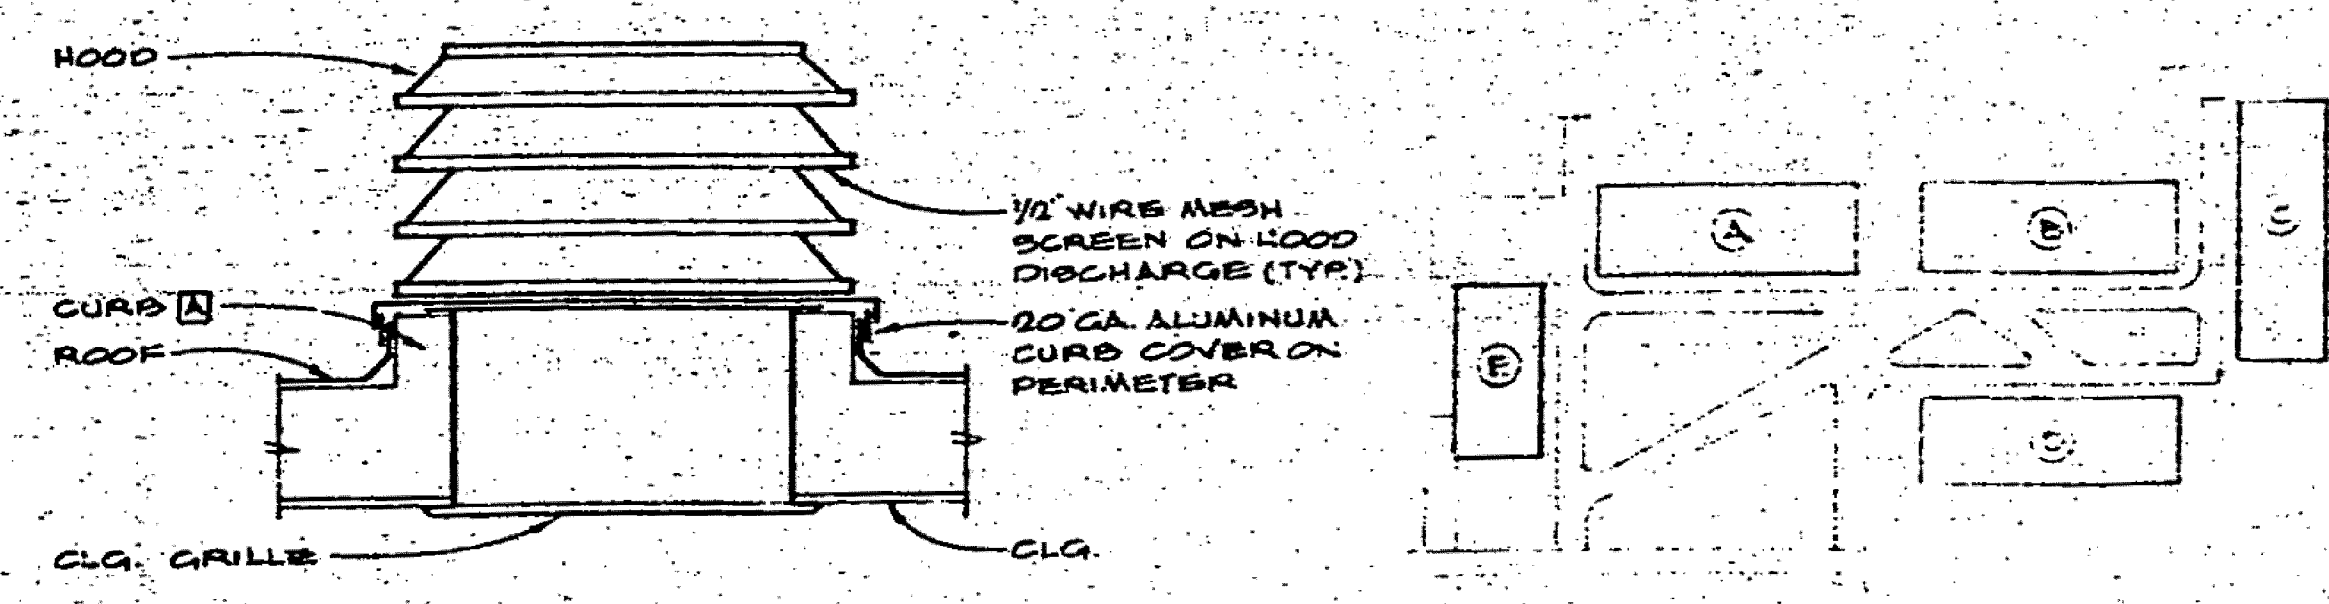

DETAIL M-4

KEY MAP
NO SCALE

H & K ENGINEERING, INC.
CONSULTING MECHANICAL ENGINEERS
100 WEST 10TH STREET
LOS ANGELES, CALIFORNIA 90017
PHONE 482-2222

KISTNER, WRIGHT & WRIGHT
ARCHITECTS AND ENGINEERS
LOS ANGELES, CALIFORNIA

STATE FIRE MARSHAL
STATE OF CALIFORNIA
APPROVED: [Signature]

MECHANICAL FLOOR PLANS-UNITS 'A', 'B', 'C', 'D', & 'E'		DATE: [Blank]	SHEET NO.:
LADE 2-1	LADE 2-2	DATE BY: [Blank]	M2
PAID: [Blank]		CHECKED BY: [Blank]	
JULIUS, [Blank]		JOB NO. [Blank]	

28550 APPROVED JAN 14 1967

CONTRACTOR TO VERIFY ALL DIMENSIONS AT THE JOB